


The Allen/Buie Partnership
Architects/Planners Incorporated
1000 Pegasus Place/Lubbock, Texas 79401-7502


**AIR CONDITIONING - MASTERS GYMNASIUM
FIRE DETECTION - WOMEN'S HIGH-RISE & DAVIS HALL
KILGORE COLLEGE**

**FIRE DETECTION
WOMEN'S HIGH RISE
FLOOR PLANS & RISER**

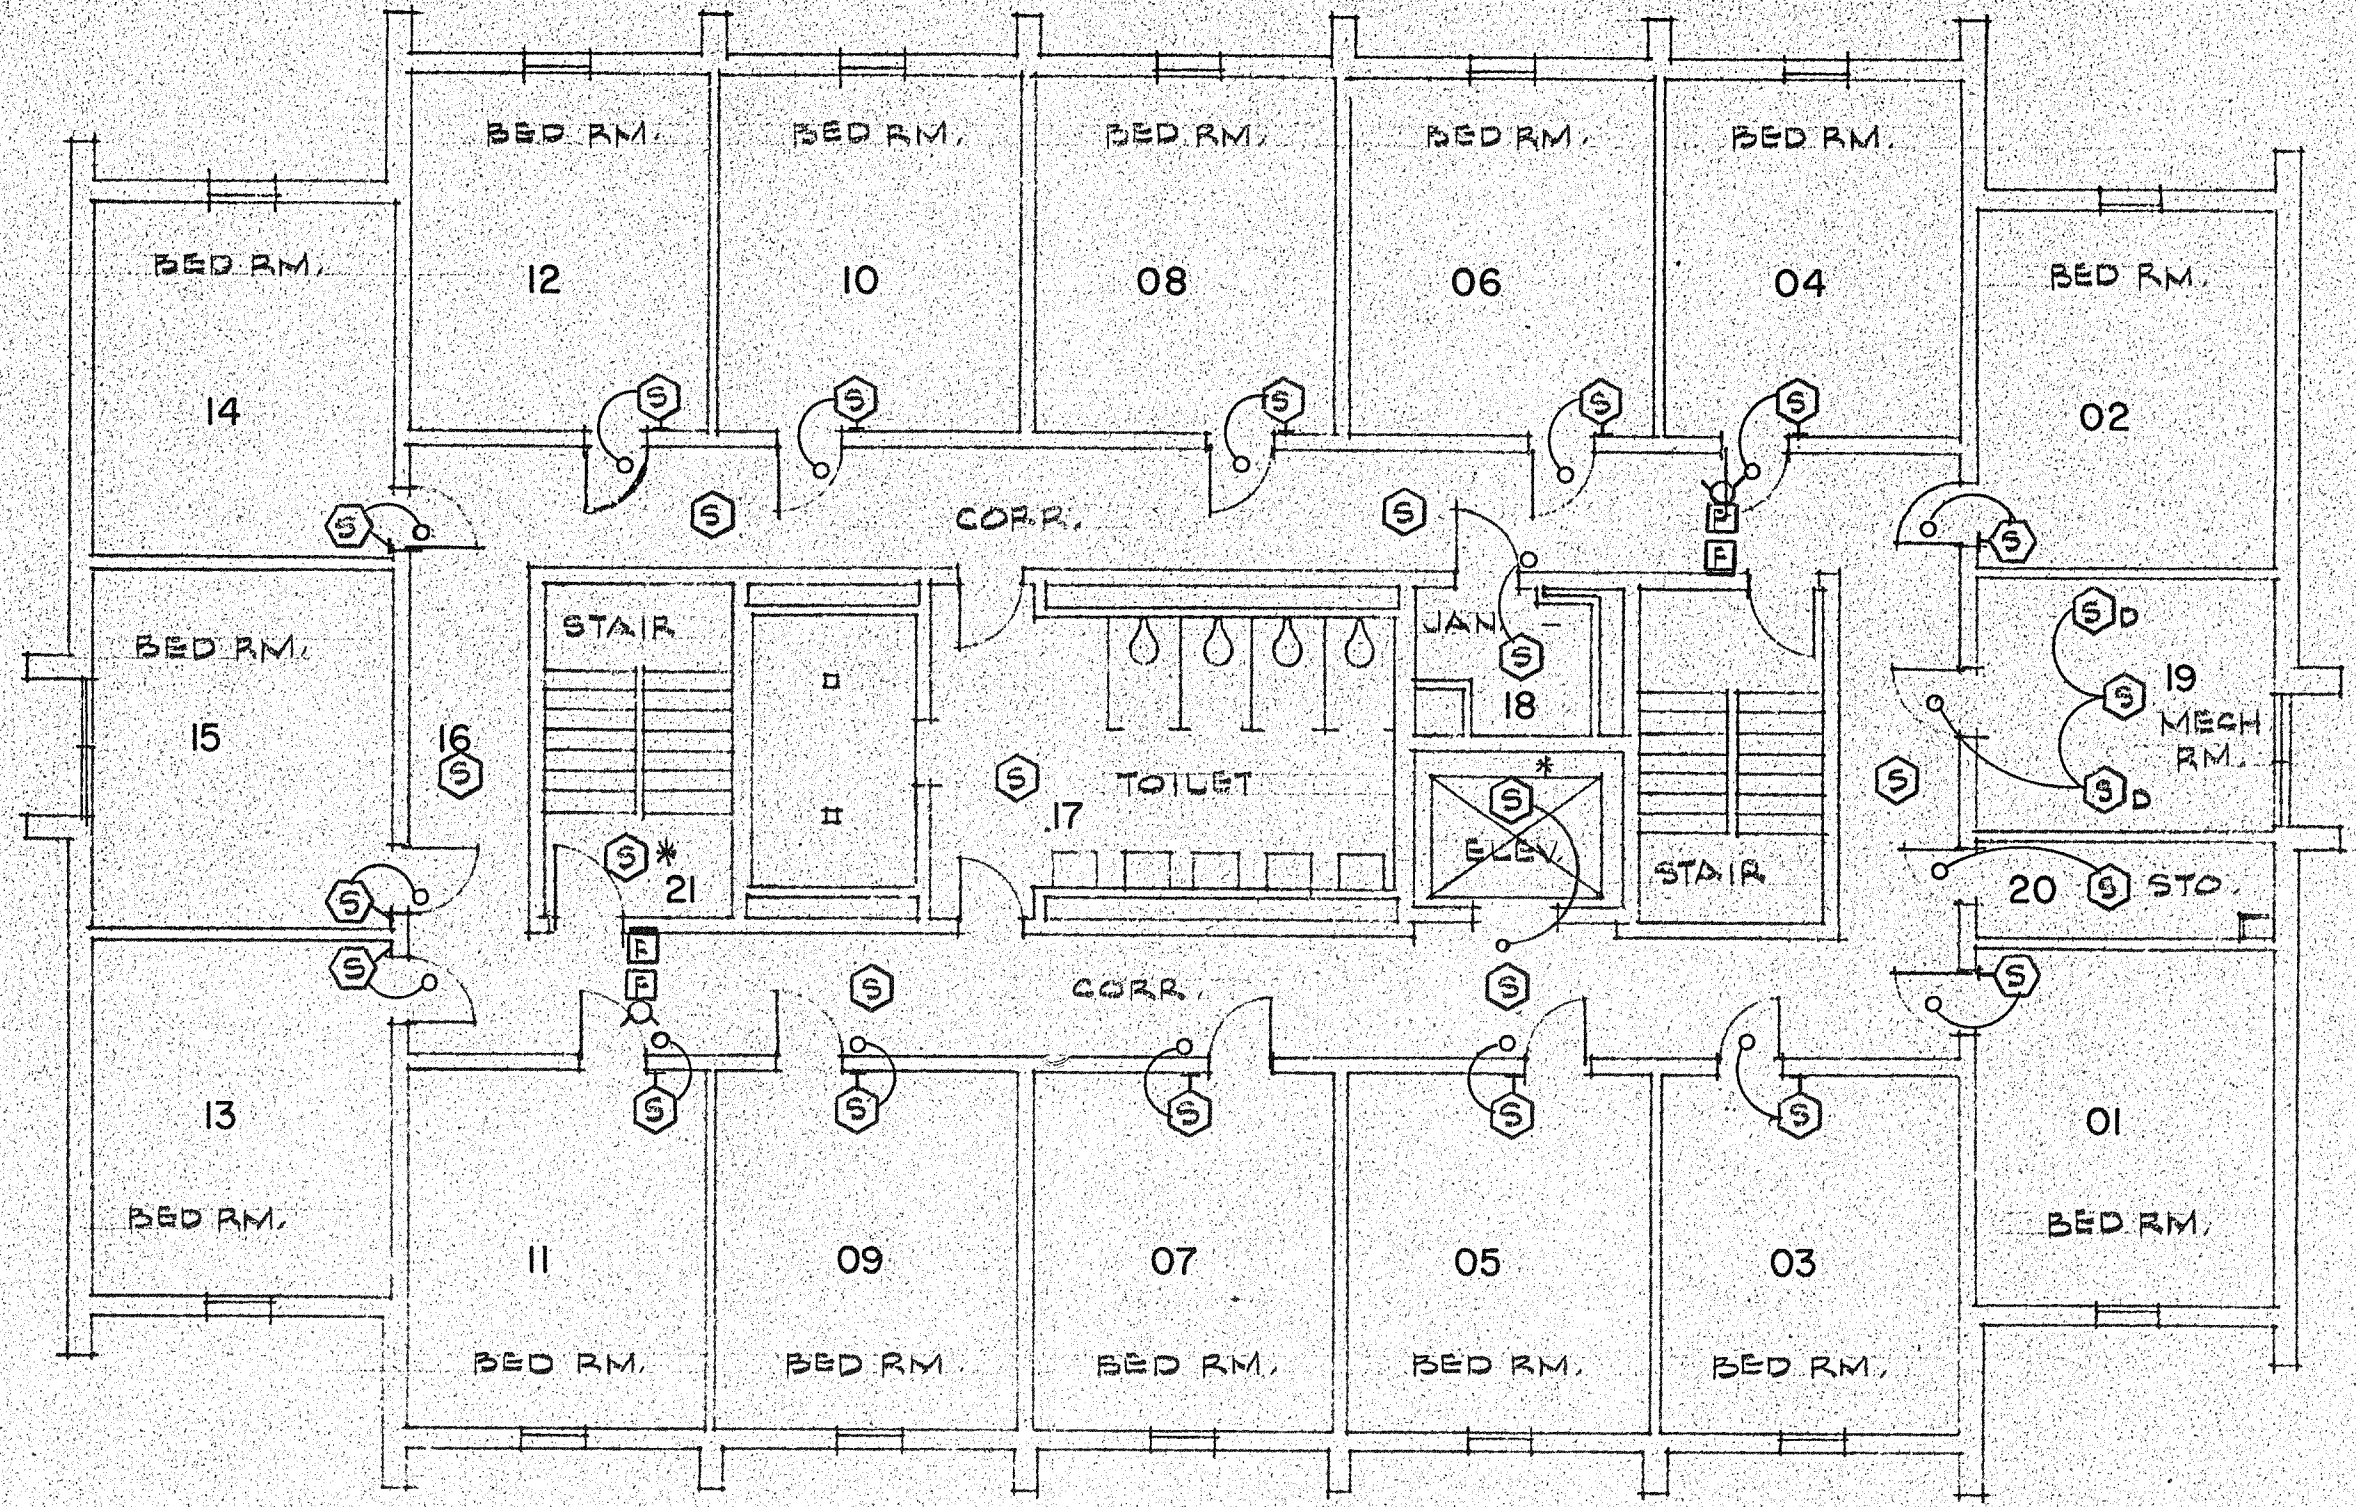


*DEVICE AT TOP OF STAIR & SHAFT ONLY

**PLAN OF FLOORS 2 THRU 8
(ZONES 2 THROUGH 8)**

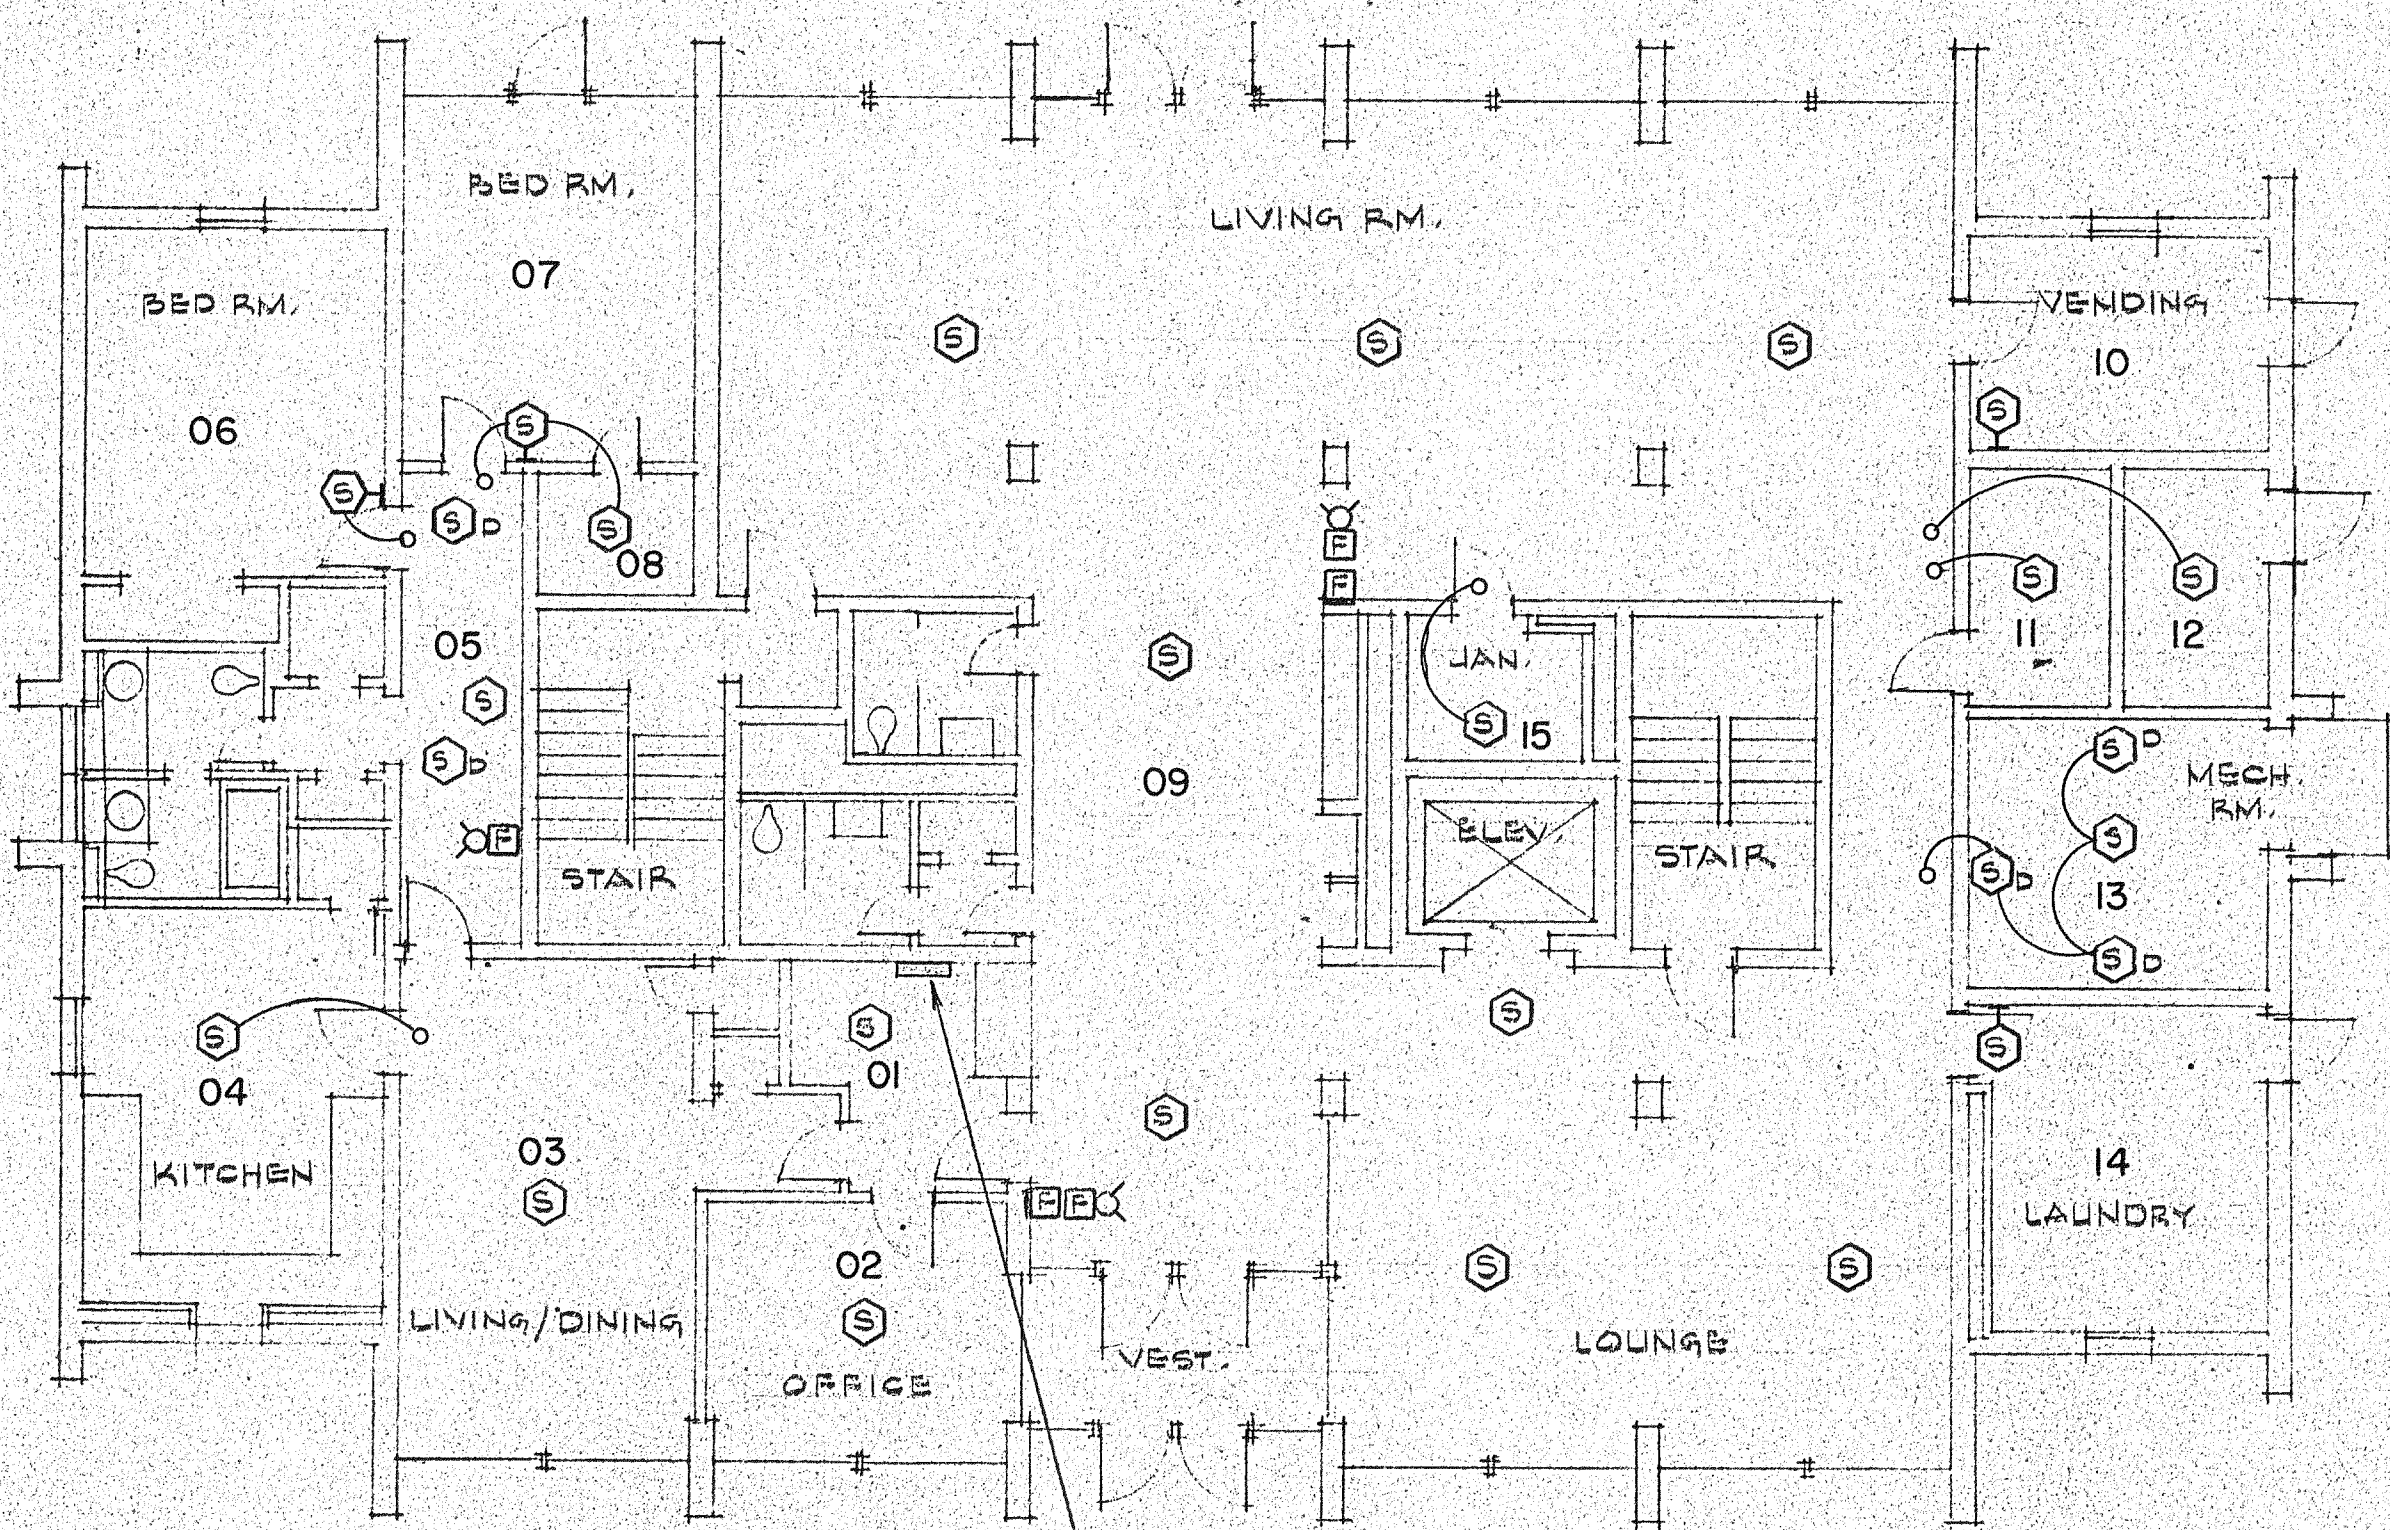


REMOVE EXISTING FIRE ALARM PANEL
AND INSTALL NEW BUILDING CONTROL
PANEL.

**WOMEN'S HIGH-RISE DORMITORY
FIRST FLOOR PLAN
SCALE 1/8" = 1'-0"
(ZONE 1)**

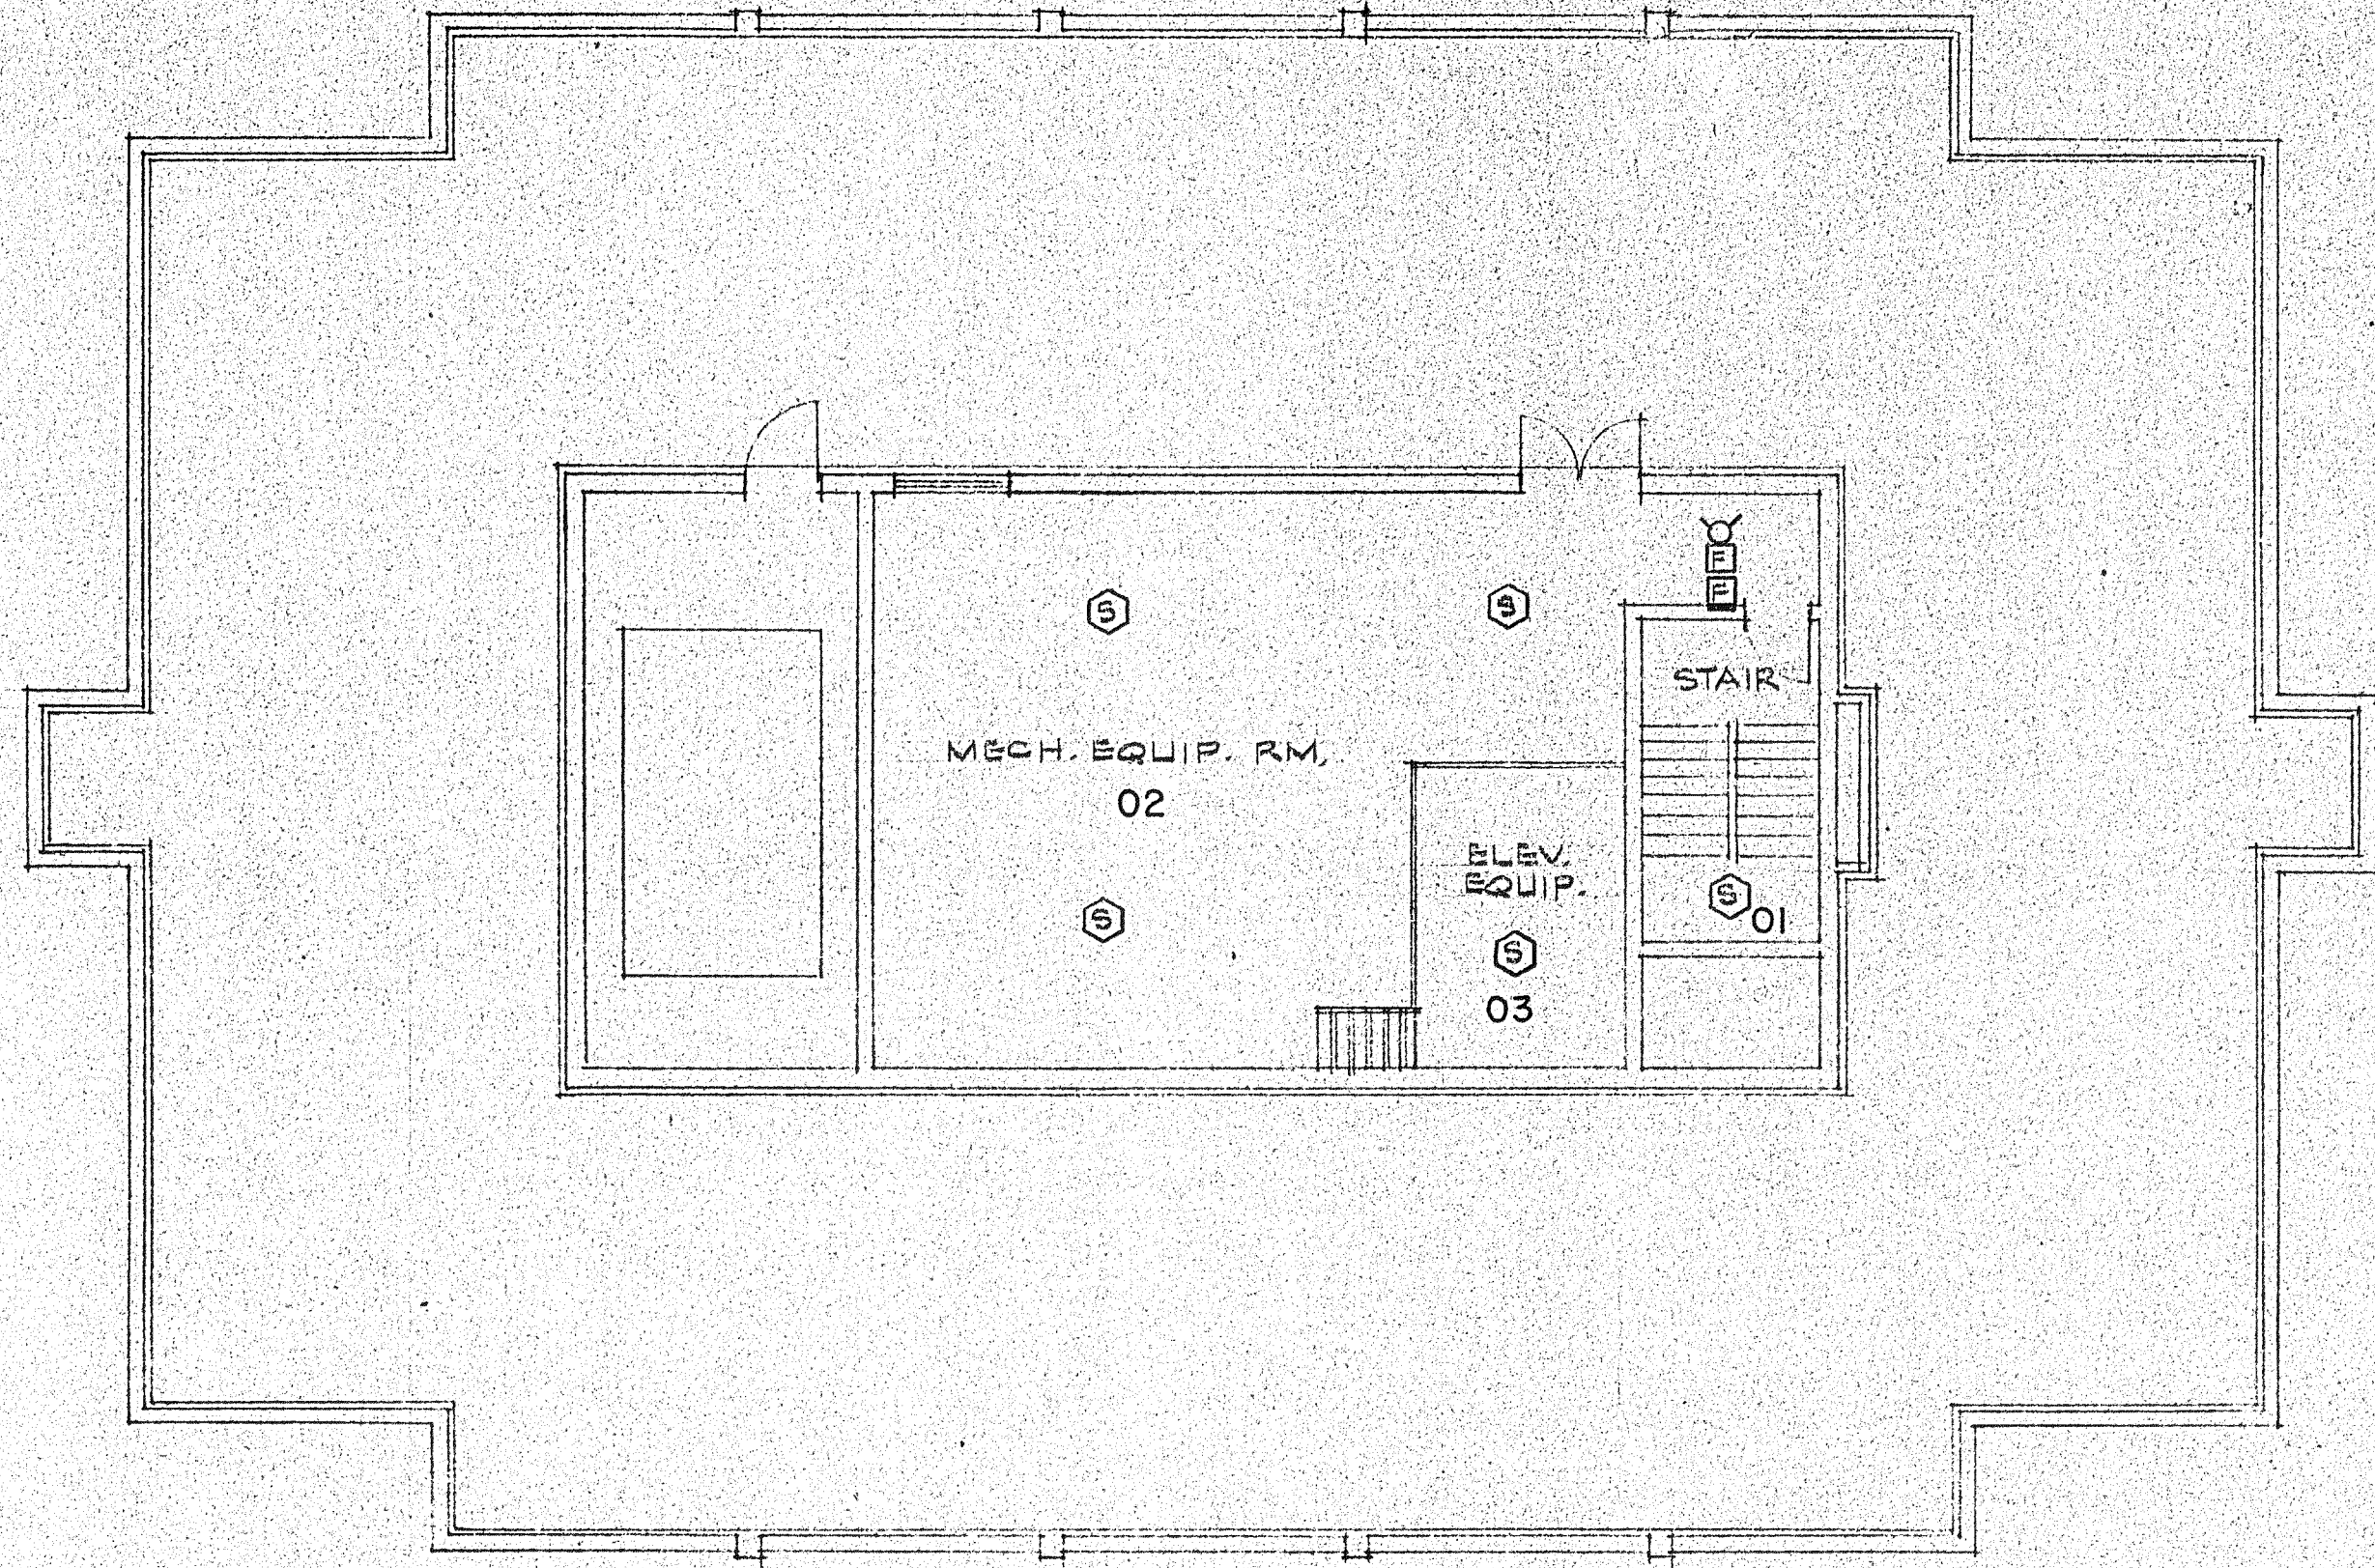


**PENTHOUSE PLAN
(ZONE 9)**

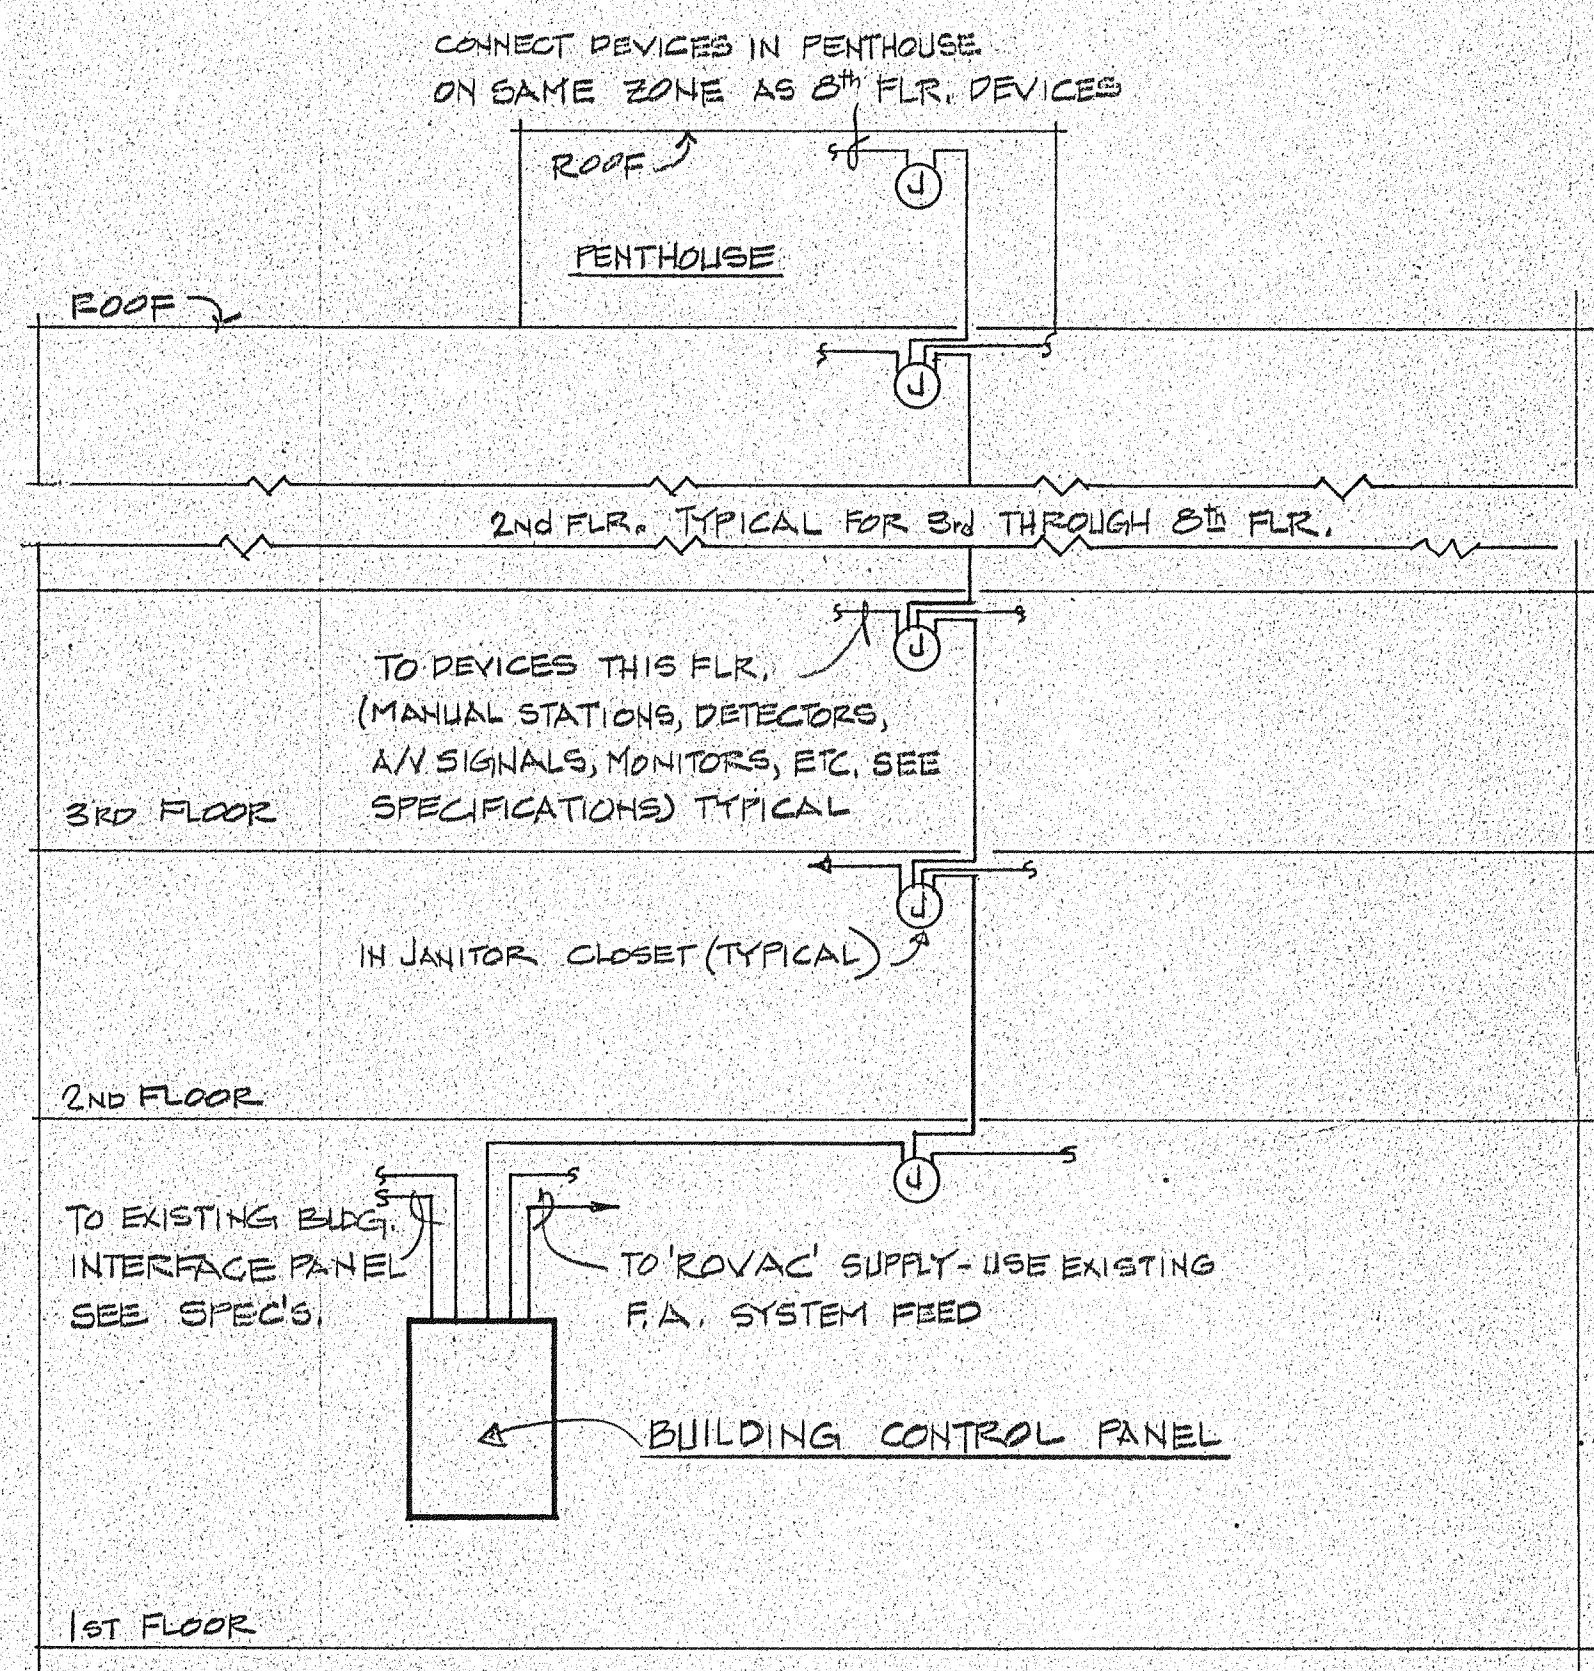


**F.A. RISER - WOMENS HI-RISE
NO SCALE**



- LEGEND**
- SD SMOKE DETECTOR
 - DD DUCT DETECTOR
 - SD SMOKE DETECTOR W/CONNECTION TO REMOTE INDICATOR LIGHTS LOCATED IN ACCESSIBLE CORRIDOR
 - MANUAL PULL STATION
 - HORN/LAMP DEVICE
 - * TOP OF STAIRWELL ONLY

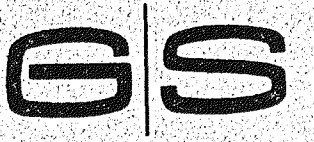

**GAYNOR
&
SIRMEN
ENGINEERS**

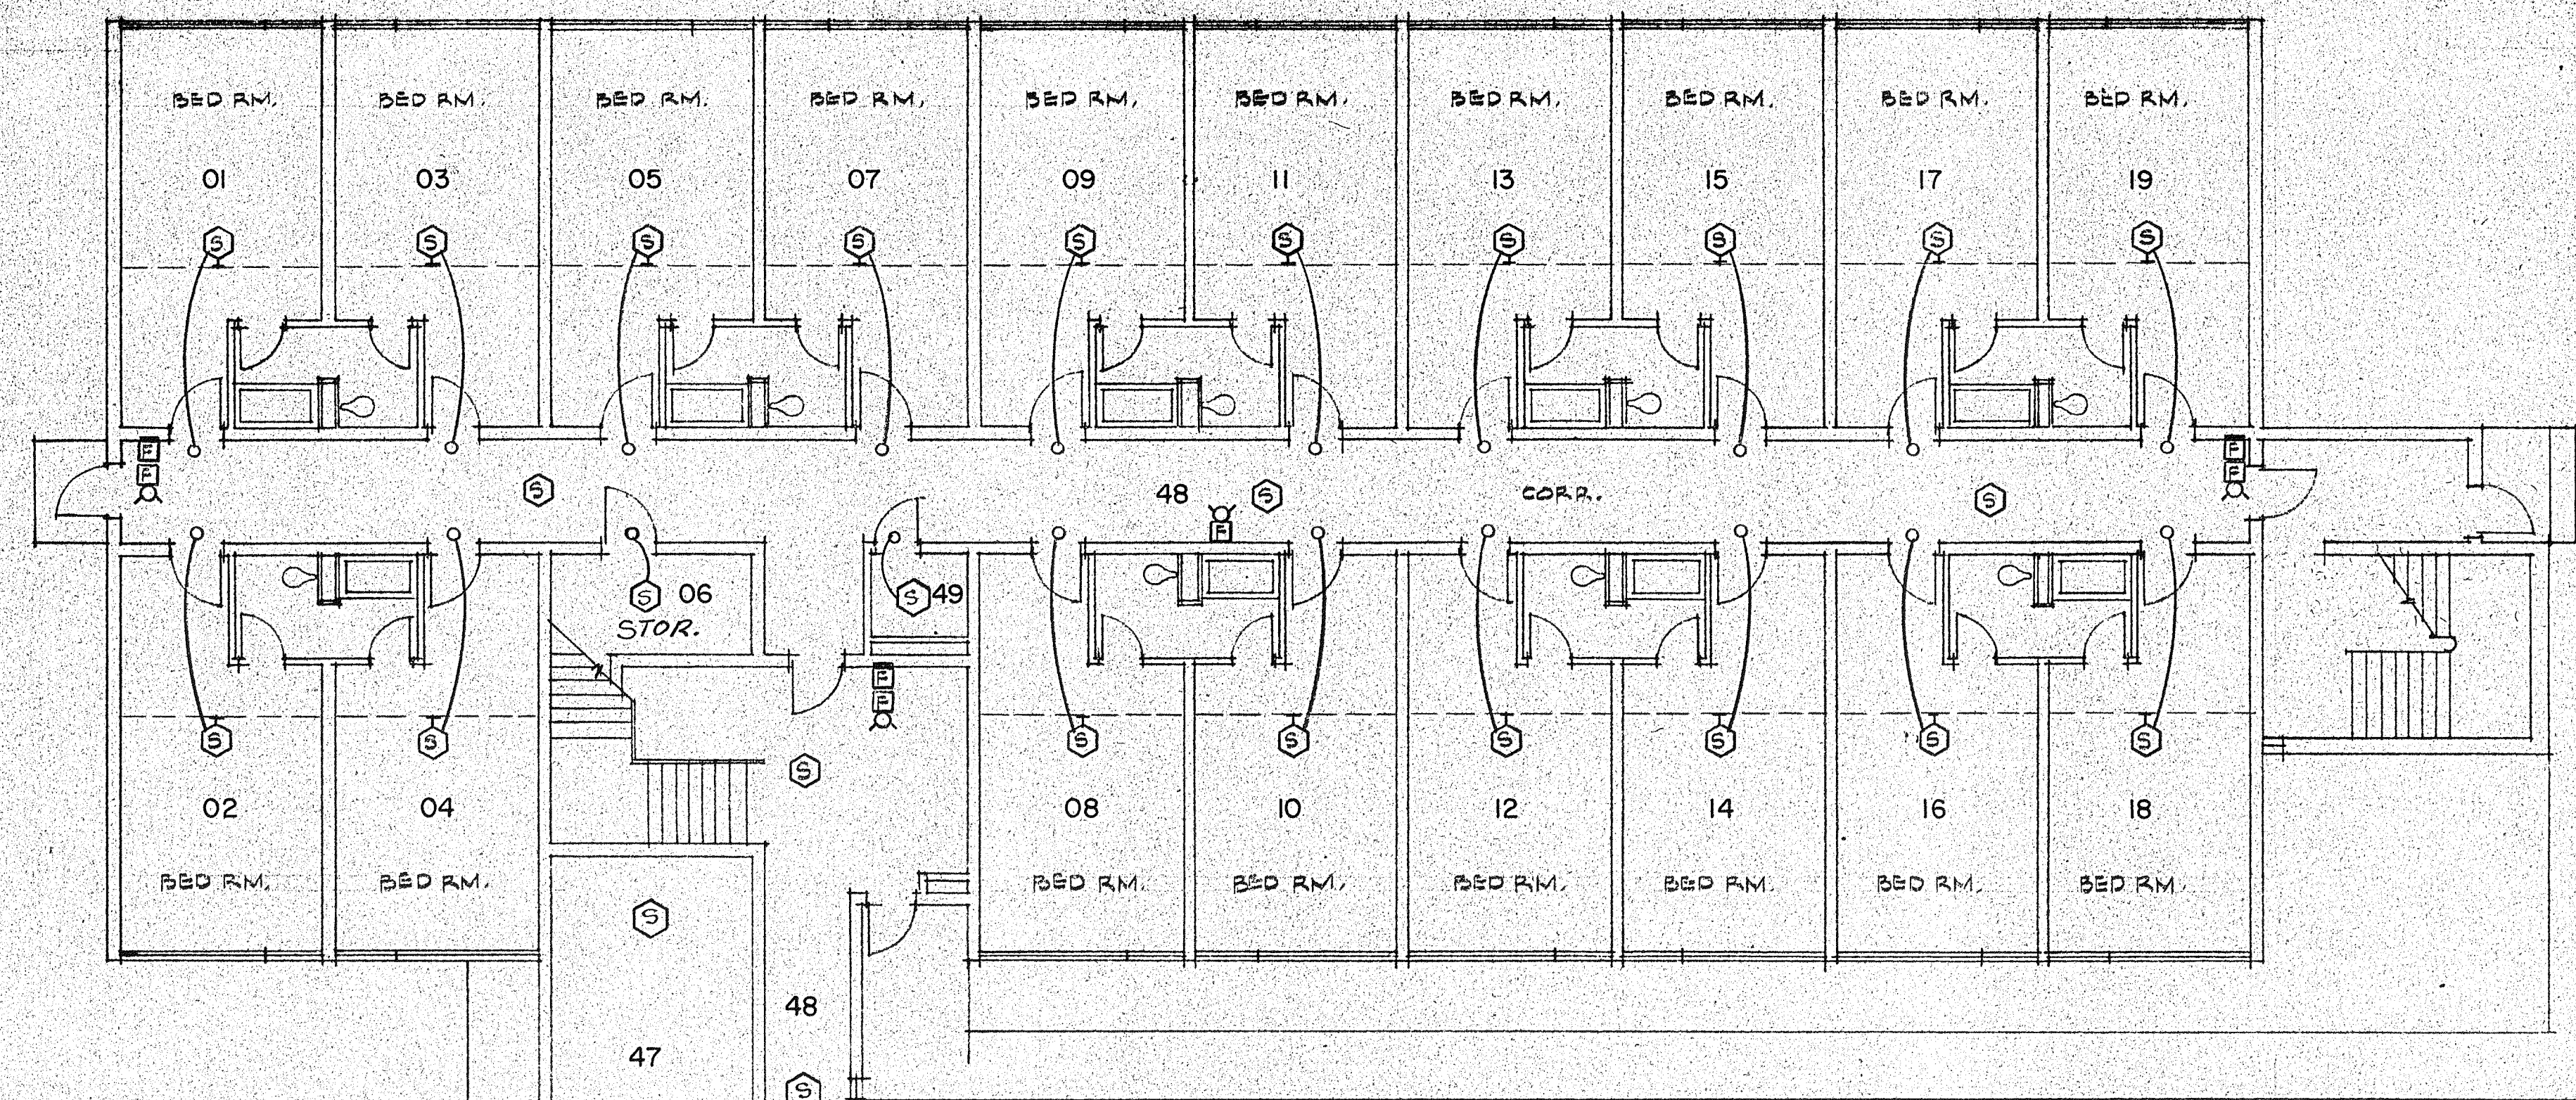


- LEGEND**
- ⑤ SMOKE DETECTOR
 - ⑤ DUCT DETECTOR
 - ⑤ SMOKE DETECTOR W/CONNECTION TO REMOTE INDICATOR LIGHTS LOCATED IN ACCESSIBLE CORRIDOR
 - ⌘ MANUAL PULL STATION
 - ⌘ HORN/LAMP DEVICE
 - * TOP OF STAIRWELL ONLY

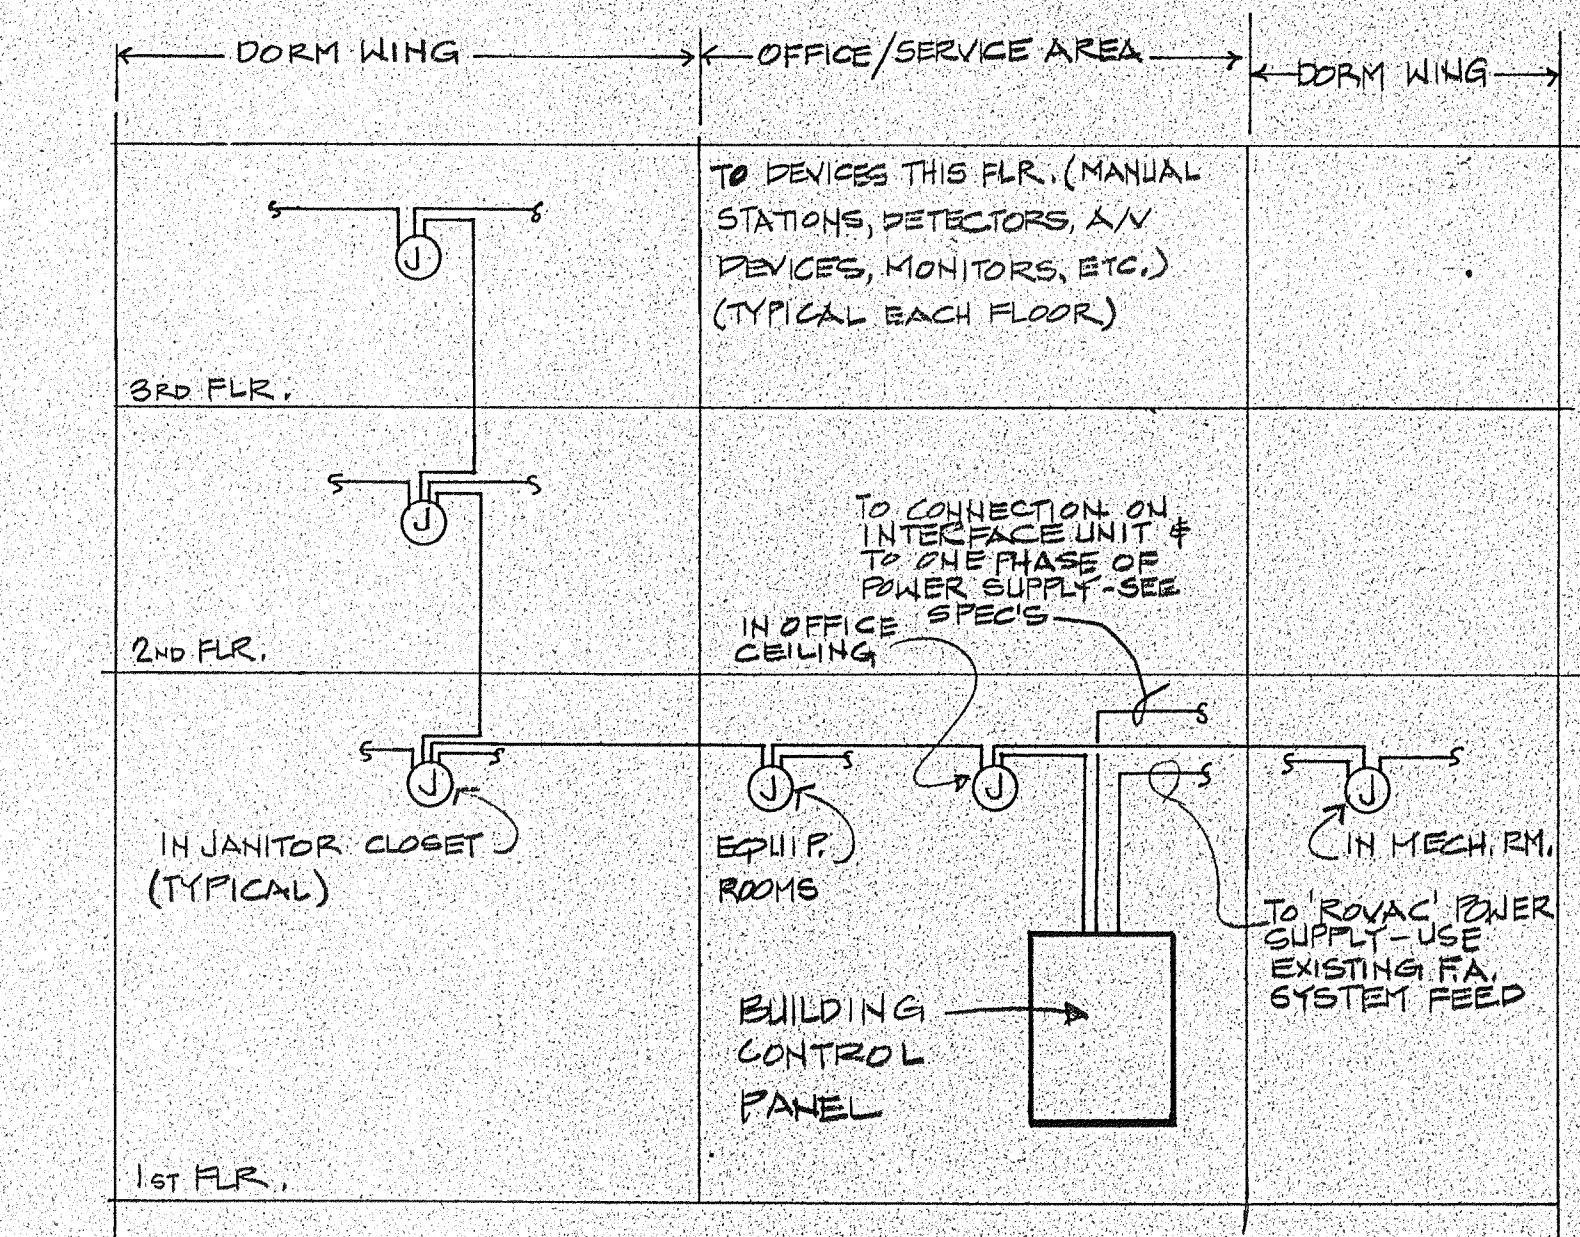
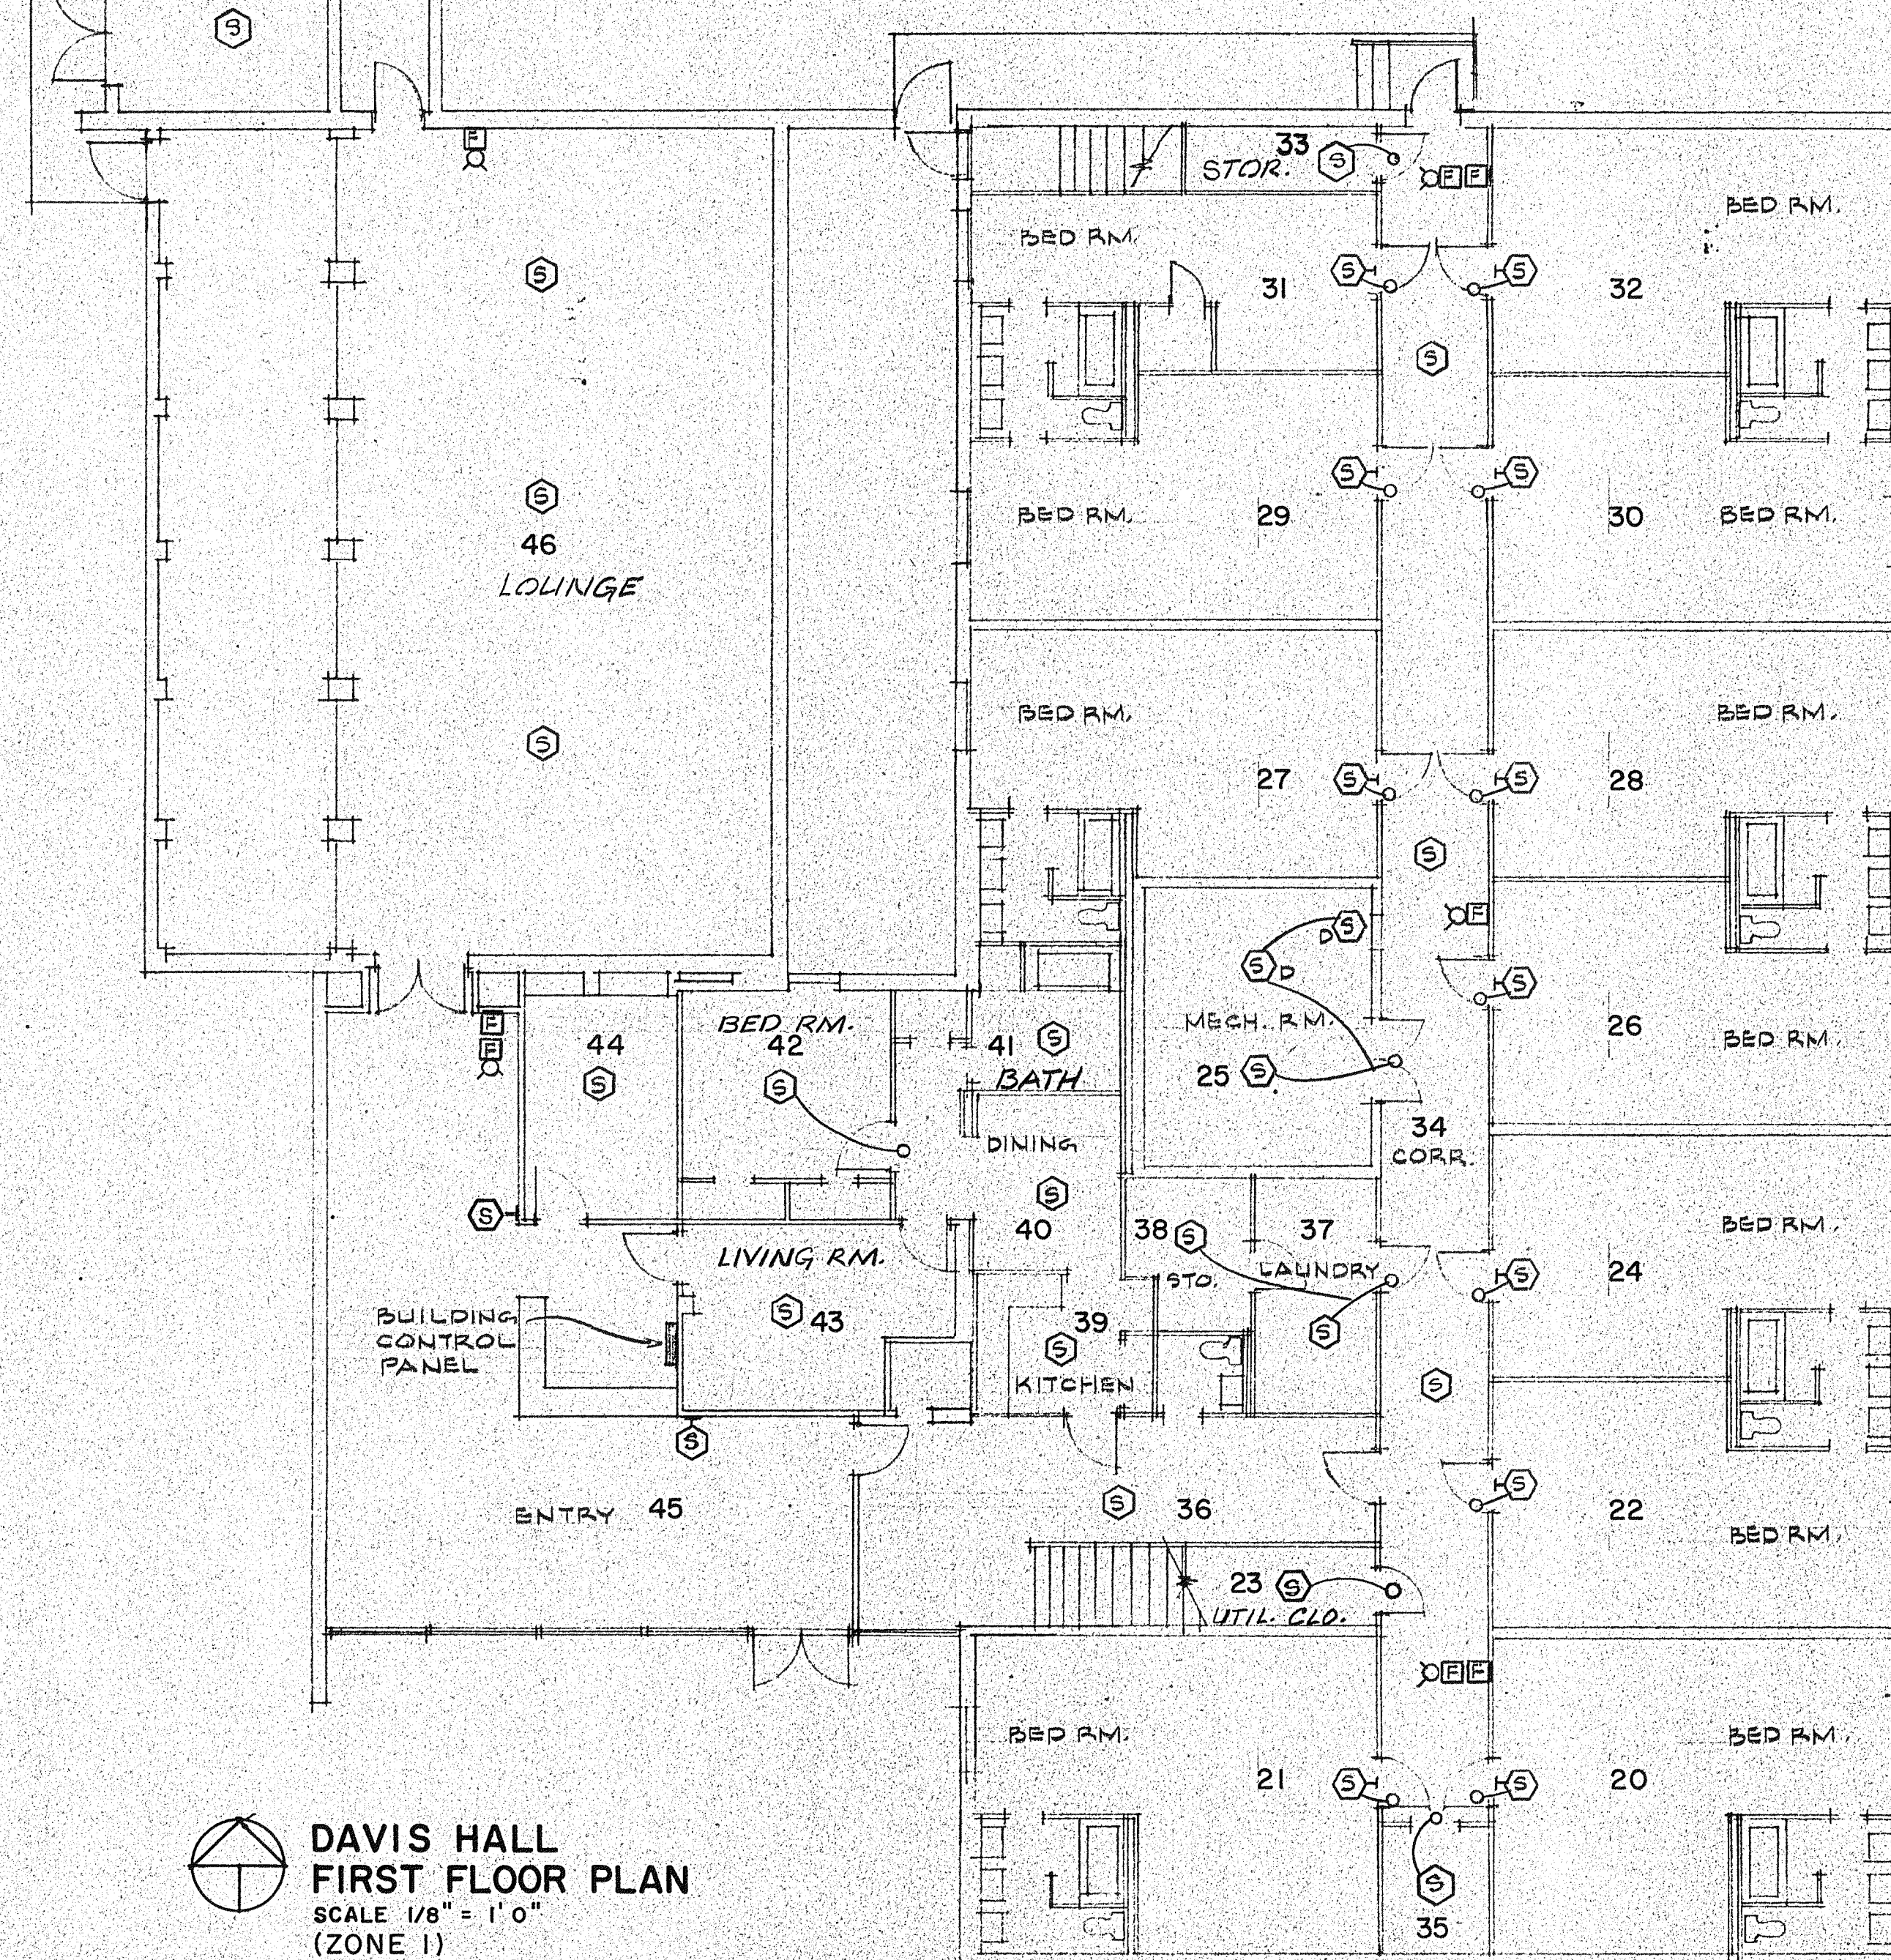


F.A. RISER - DAVIS HALL
NO SCALE

DAVIS HALL
FIRST FLOOR PLAN
SCALE 1/8" = 1' 0"
(ZONE 1)

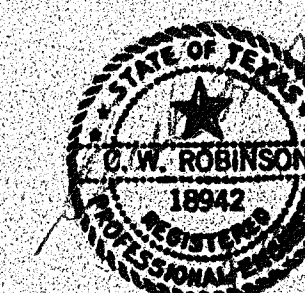

**GAYNOR
&
SIRMEN**
ENGINEERS

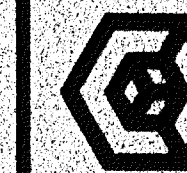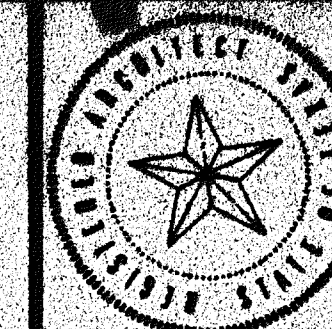

**The Allen/Buie
Partnership**


Architects/Planners Incorporated
1000 Pagurus Place Longview, Texas 75601 (214) 765-5502

**AIR CONDITIONING - MASTERS GYMNASIUM
FIRE DETECTION - WOMEN'S HIGH-RISE & DAVIS HALL
KILGORE COLLEGE**


**FIRE DETECTION
DAVIS HALL
FIRST FLOOR PLAN**

FA-2

NOTE: REPEAT THIS PORTION OF PLAN FOR THIRD FLOOR. PLAN IS IDENTICAL EXCEPT SECOND LEVEL KITCHEN ADJACENT TO WEST STAIR IS LAUNDRY AT THIRD FLR. (ZONES 2 AND 3)

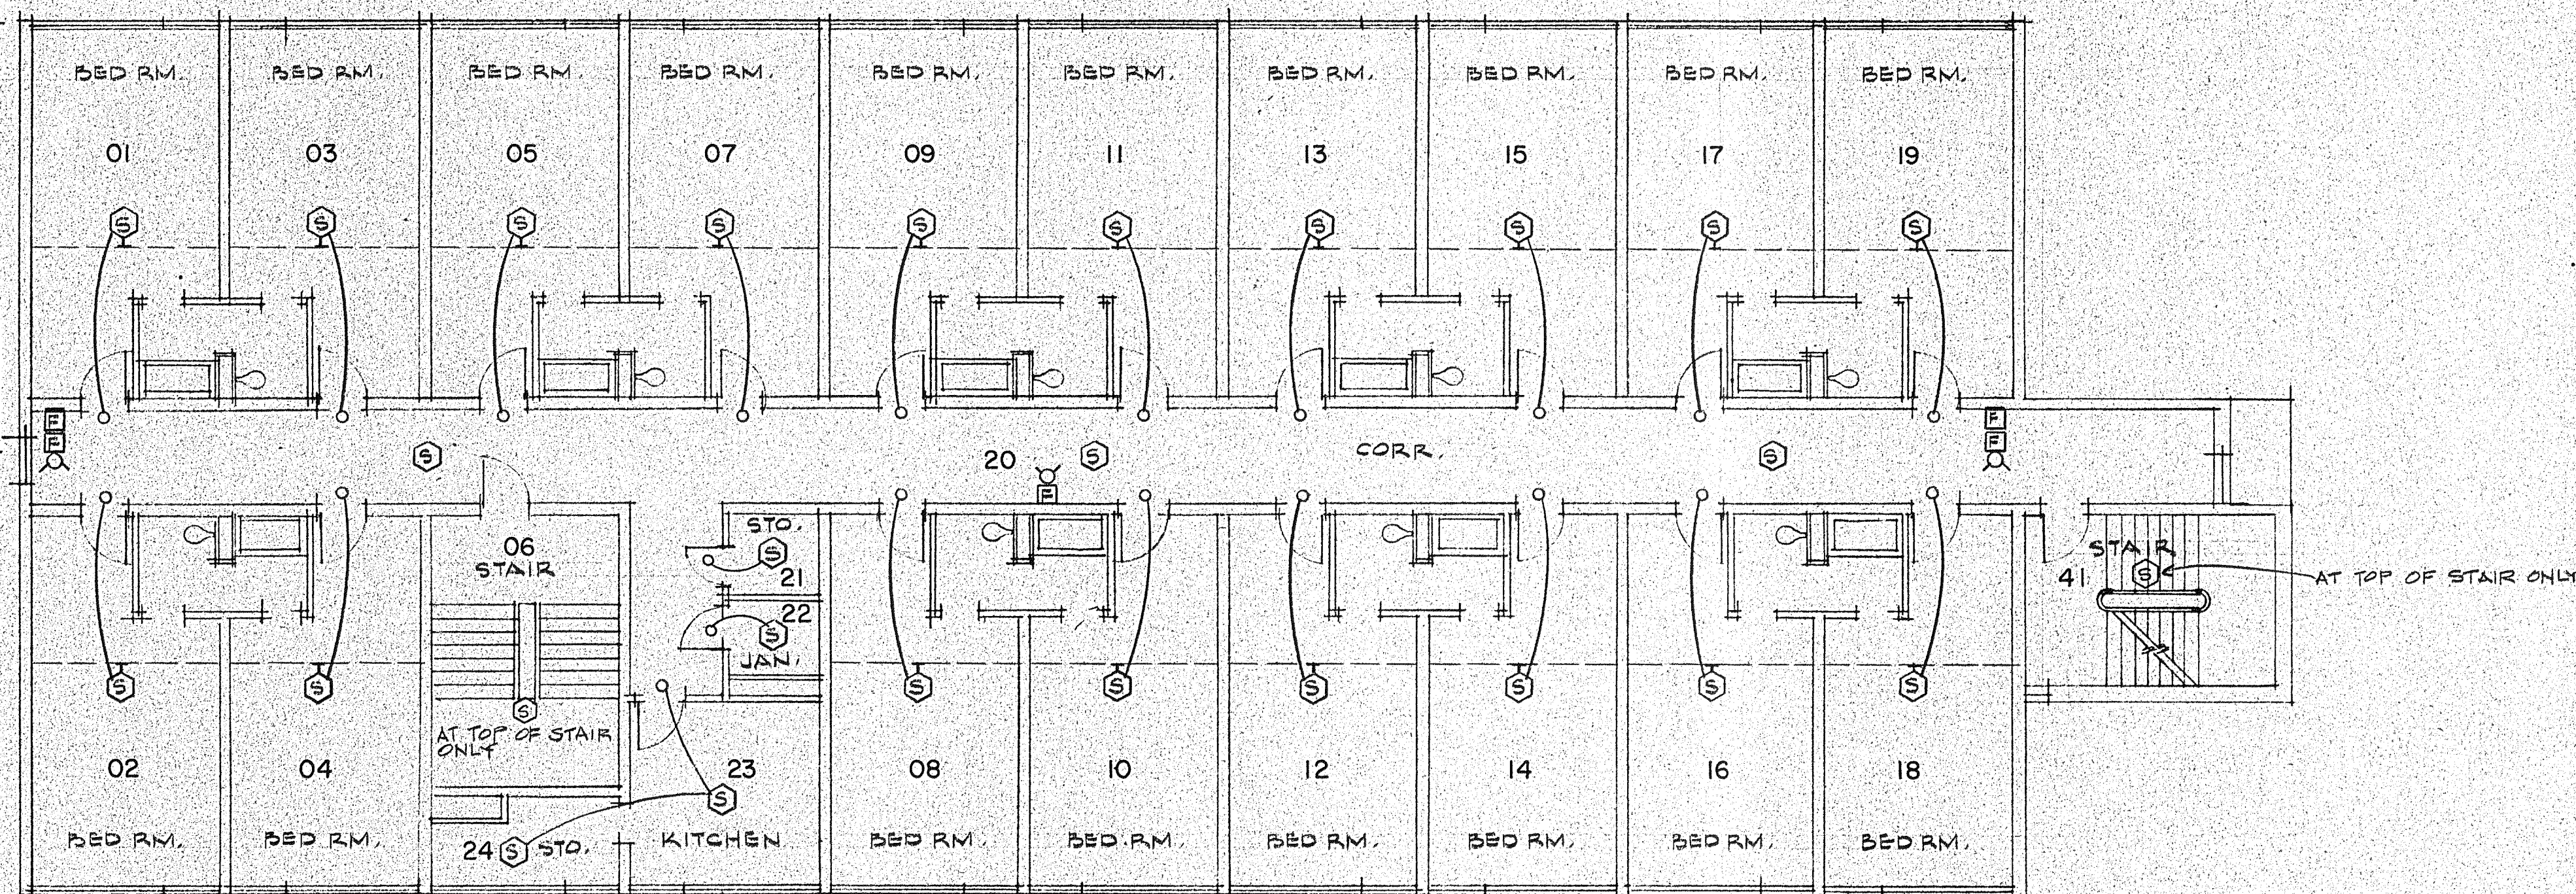

DAVIS HALL
SECOND FLOOR PLAN
SCALE 1/8" = 1' 0"
(ZONE 2)

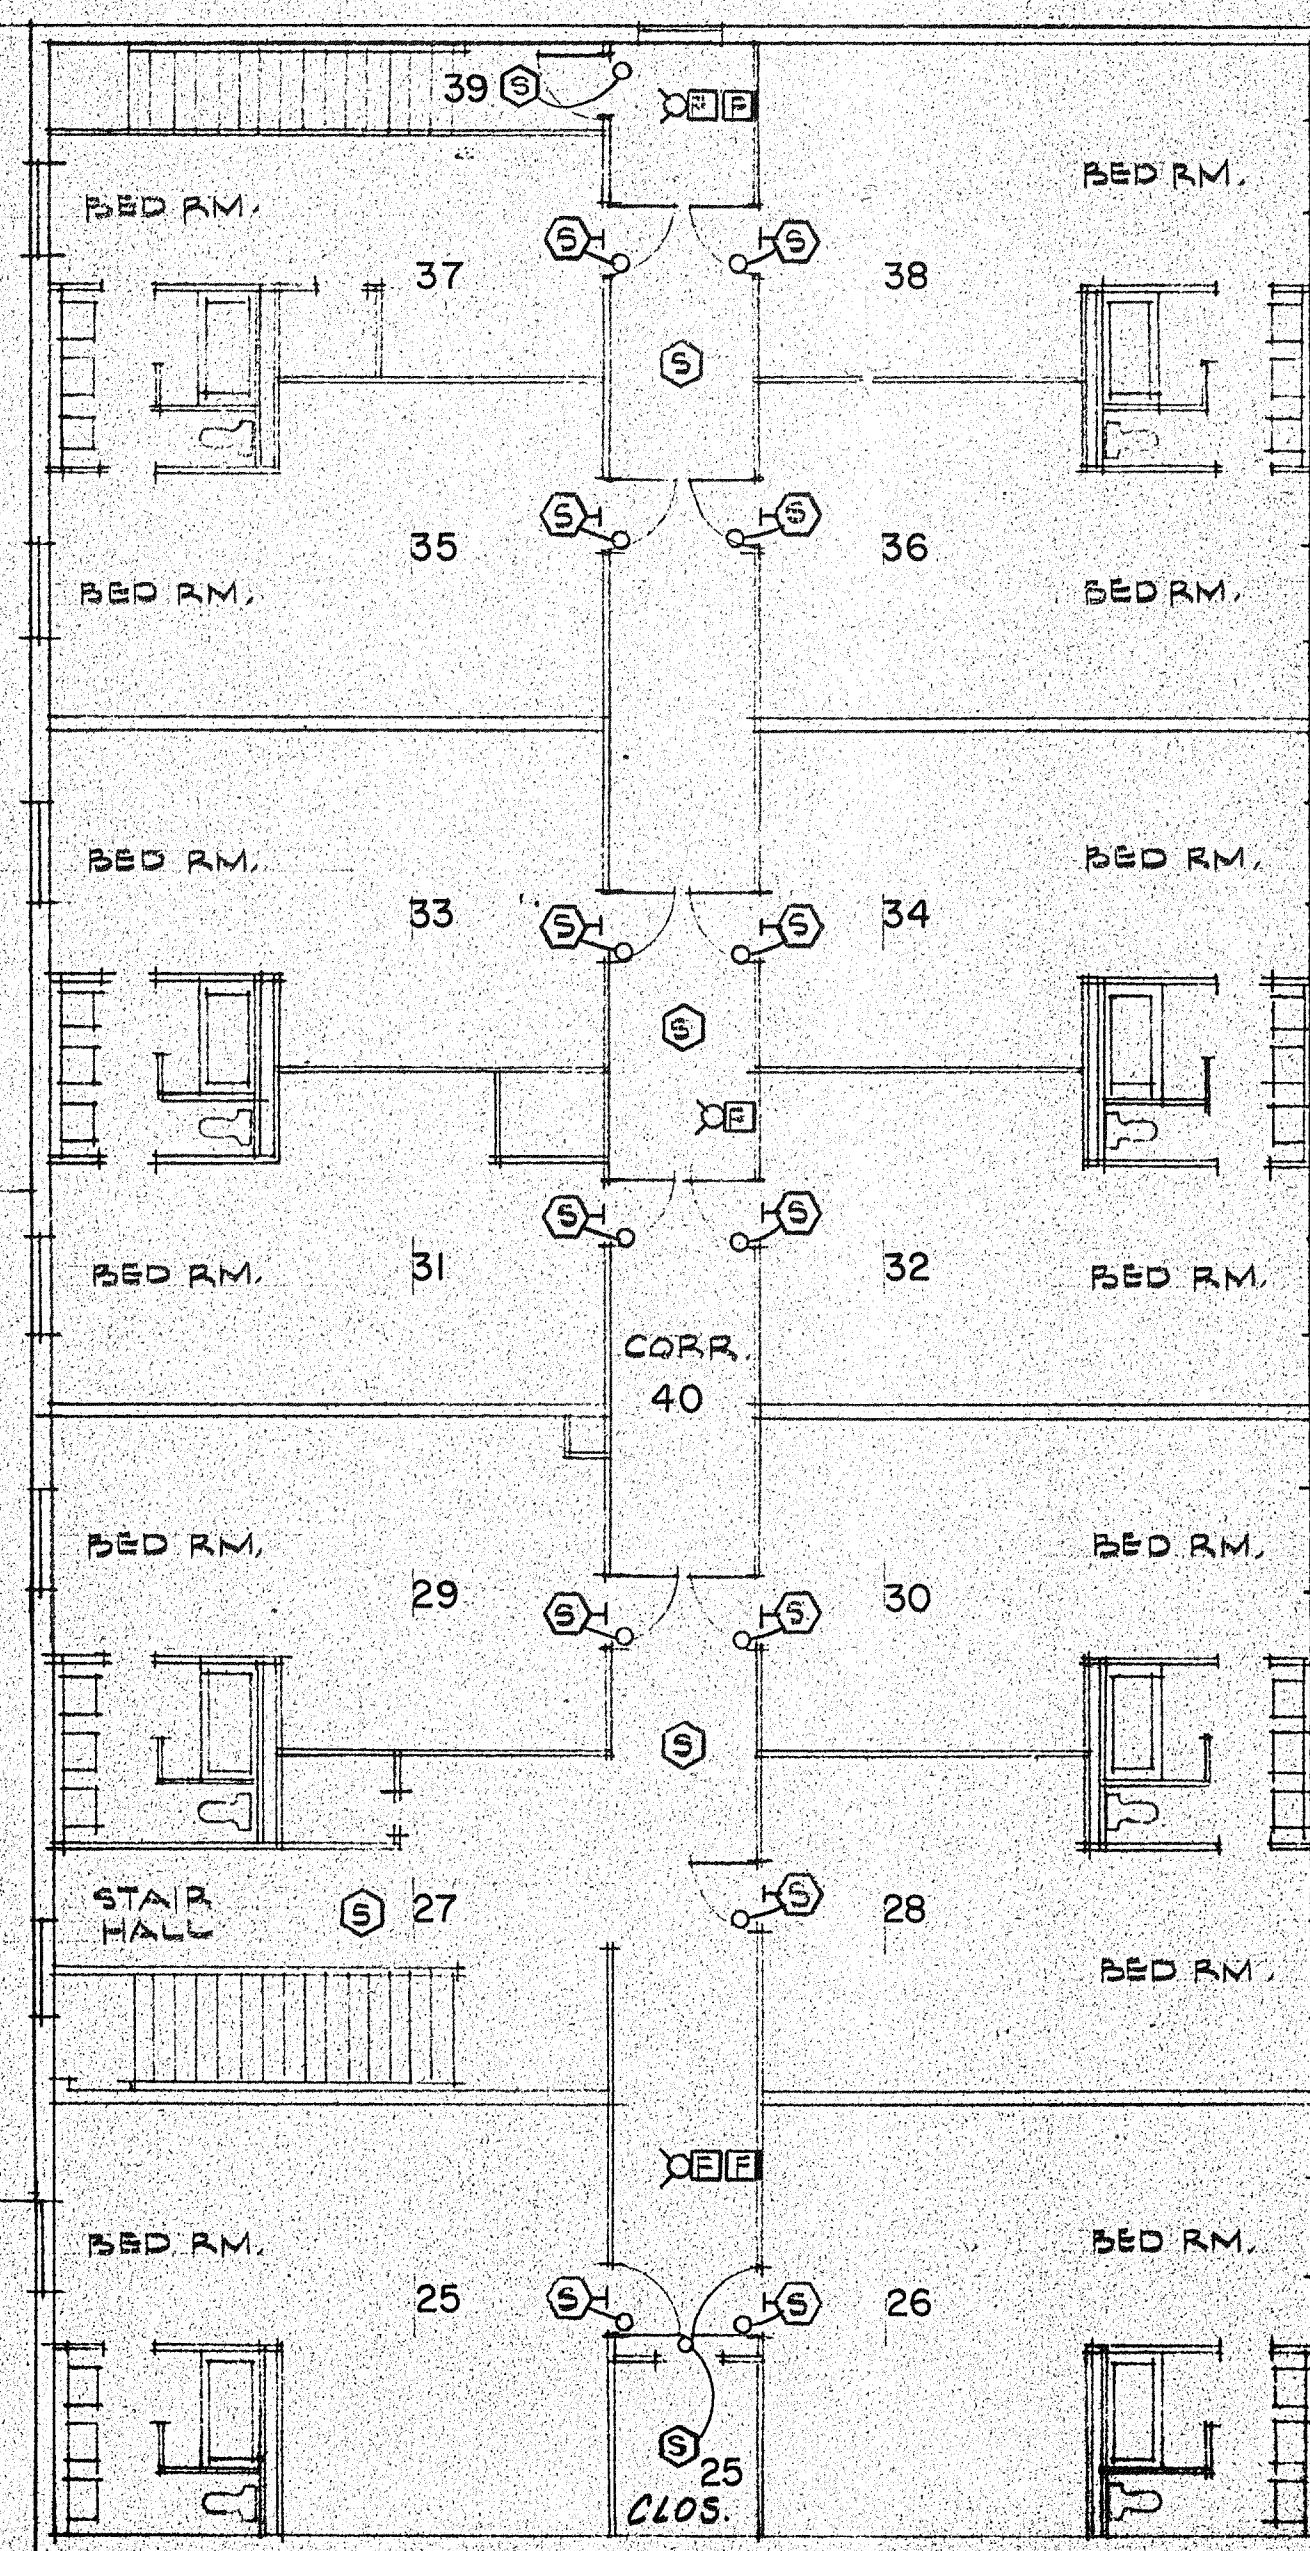

GS

GAYNOR
&
SIRMEN
ENGINEERS

FIRE DETECTION
DAVIS HALL
SECOND FLOOR PLAN

FA-3

AIR CONDITIONING - MASTERS GYMNASIUM
FIRE DETECTION - WOMEN'S HIGH-RISE & DAVIS HALL
KILGORE COLLEGE

The Allen/Buie
Partnership

Architects/Planners Incorporated
1000 Pegasus Place / Longview, Texas 75601 / 214/755-5502

